


MATERIAL LIST

No. QTY	DESCRIPTION
1	1 GANTRY WITH DIGITAL DETECTOR (20000 FFM)
2	1 MONITOR CART
3	1 RADIATION SHIELD & CONTROL CONSOLE
4	1 TDK WORKSTATION
5	1 UPS (12.5 KVA)
6	1 XRAY GENERATOR CABINET
7	1 CONDITIONER CABINET
8	1 TOILET
9	1 BATH CABINET- STORAGE & 19" RACK FOR SAT DISH
10	1 ERM CURTAINS
11	1 BED CURTAINS
12	1 ULTRASOUND LOGBOOK
13	1 STAIRS/PLATFORM
14	1 SAT DISH - TO BE DETERMINED
15	15FB3 SPACE HEATERS AS REQUIRED (NOT SHOWN)
16	2 SLIDEOUT WALL SECTION
17	1 AIR CONDITIONER WITH HEAT PACKAGE - SIZE TBD
18	1 2-TON PANDA GENERATOR (NOT SHOWN & TO BE VERIFIED)
19	1 LOAD CENTER
20	1 FOLD DOWN WORKTOP FOR LOGBOOK
21	1 FOLD DOWN WORKTOP FOR LOGBOOK
22	4 HYDRAULIC LEVELING LEGS (15,000 LB. CAP.)
23	1 FREIGHTLINER FL-80 288 WHEELBASE
24	1 WHEEL CHAIR LIFT, CASSETTE STYLE
25	1 BONE DENSITOMETER ACHILLES INSIGHT
26	2 ROLL AROUND STOOL
27	1 BENCH SEAT WITH STORAGE BELOW
28	1 PLASMA SCREEN TO BE DETERMINED
29	1 TV
30	1 FOLD DOWN WORK TOP

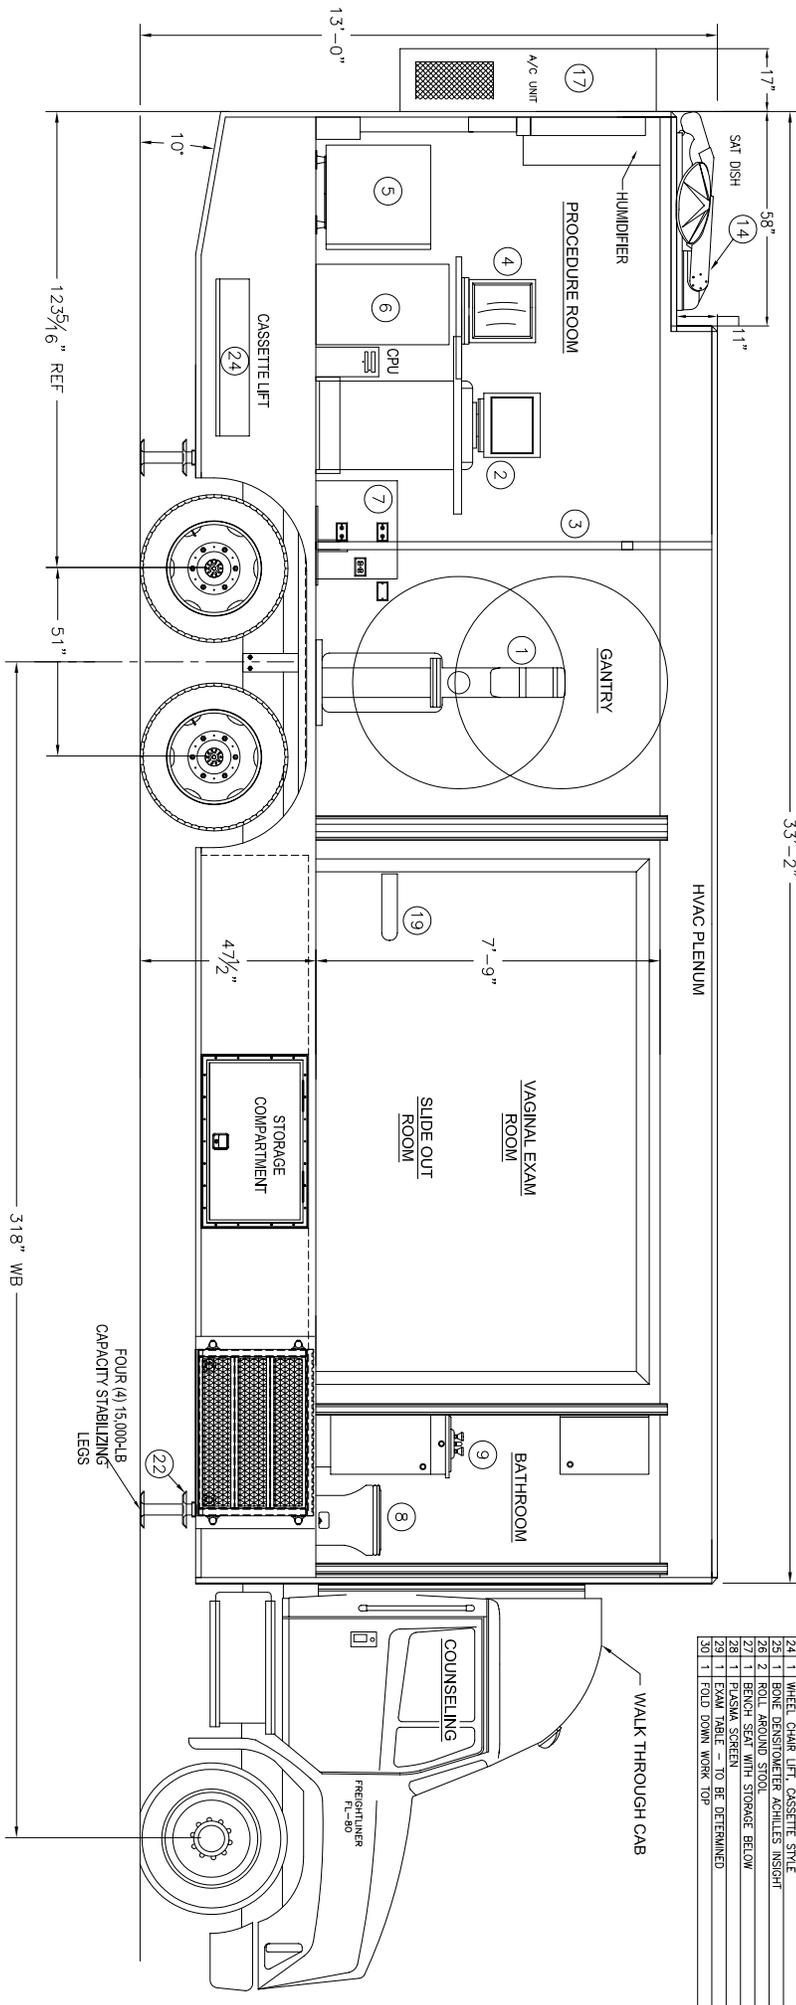

CUSTOMER AUTHORIZATION

NAME (PRINT) _____ TITLE _____

ORGANIZATION _____ DATE _____

JOB # _____

SHEET 2 OF 2

CREATED 2 SHEETS, ACCORDIAN DOOR FOR BATH 8/25/03

DESCRIPTION REVISIONS DATE REV

THIS DRAWING IS AN INSTRUMENT OF PROFESSIONAL SERVICE. IT IS THE PROPERTY OF THE ENGINEER OR ARCHITECT AND SHALL BE RETURNED TO THE ENGINEER OR ARCHITECT UPON COMPLETION OF THE PROJECT. IT IS NOT TO BE REPRODUCED OR TRANSMITTED IN ANY FORM OR BY ANY MEANS, ELECTRONIC OR MECHANICAL, INCLUDING PHOTOCOPYING, RECORDING, OR BY ANY INFORMATION STORAGE AND RETRIEVAL SYSTEM, WITHOUT THE WRITTEN PERMISSION OF THE ENGINEER OR ARCHITECT.

TITLE: GENERAL LAYOUT - INDIAN RESERV

GENERAL ELECTRIC SENSOPART 2000 D

IN A 40 FREIGHTLINER FL-80 TRUCK

1846 S. LUMBER AVENUE
P.O. BOX 100
PUEBLO, CO 81001
Phone: (781) 546-5066
Fax: (781) 546-2480

APPROVED BY: _____

DRAWN BY: _____

DATE: 30 JUL 03

SCALE: 1/2" = 1'-0"

DRAWING NUMBER: P-01895-A

REV: 07